

VICINITY MAP  
N.T.S.


GENERAL NOTES

- LETTERS AND NUMBERS IN INDICATE THE DETAIL CALL-OUT AND SHEET ON WHICH REFERENCE DETAIL IS SHOWN
- AREA DESIGNATED BY IS THE AREA OF THE PROPERTY TO BE SERVED WITH RECYCLED WATER.
- LEMONS ARE TO BE IRRIGATED USING RECYCLED WATER SERVICE.
- WHEN RECYCLED WATER IS NOT AVAILABLE LEMONS ARE TO BE IRRIGATED USING POTABLE WATER SERVICE
- POTABLE WATER POINT OF CONNECTION SHALL BE EQUIPPED WITH AN APPROVED AIR GAP. THE AIR GAP SHALL BE AT LEAST TWICE (2X) THE DIAMETER OF THE SUPPLY PIPE AND IN NO CASE LESS THAN 1" (SEE DETAIL 13 ON SHEET 10)
- ALL PRESSURE MAIN LINE PIPING FROM THE RECYCLED WATER SYSTEM SHALL BE INSTALLED TO MAINTAIN A TEN (10) FOOT MINIMUM HORIZONTAL SEPERATION FROM ALL POTABLE WATER PIPING. WHERE RECYCLED AND POTABLE WATER PRESSURE MAINLINE PIPING CROSSES, THE RECYCLED WATER PIPING SHALL BE INSTALLED BELOW THE POTABLE WATER PIPING TO PROVIDE A MINIMUM VERTICAL CLEARANCE OF ONE (1) FOOT AND SHALL BE INSTALLED IN A PVC CLASS 200 PIPE SLEEVE WHICH EXTENDS A MINIMUM OF FIVE (5) FEET ON EITHER SIDE OF THE POTABLE WATER PIPING.
- ALL BURIED RECYCLED WATER DISTRIBUTION PIPING, INCLUDING MAIN AND LATERAL LINES, VALVES AND OTHER APPURTENANCES SHALL BE COLOR EXTRUDED PURPLE, PANTONE 512, AND EMBOSSED OR INTEGRALLY STAMPED/MARKED BY THE MANUFACTURER EVERY 24 INCHES ON TWO (2) SIDES: "CAUTION: RECYCLED WATER - DO NOT DRINK"
- ALL ABOVEGROUND RECYCLED WATER FACILITIES (CONTROLLERS, VALVES, RISERS, HEADS, QUICK COUPLERS, ETC.) SHALL HAVE IDENTIFYING COLORS AND LABELS FOR RECYCLED WATER.
- SIGNS SHALL BE POSTED AT THE ENTRANCES TO THE SITE AND AT OTHER LOCATIONS ON THE SITE AS REQUIRED, NOTING THAT RECYCLED WATER IS BEING USED ONLY FOR IRRIGATION PURPOSES.

INDEX TO SHEETS

SHEET NO.	TITLE
6.	GENERAL PLAN
7.	IRRIGATION SYSTEM PIPING PLAN NORTH PARCELS
8.	IRRIGATION SYSTEM PIPING PLAN SOUTH PARCELS
9.	IRRIGATION SYSTEM DETAIL
10.	IRRIGATION SYSTEM DETAIL
11.	HYDRAULIC ANALYSIS

UNDERGROUND SERVICE ALERT  
1-800-422-4133  
CALL USA/SC  
FOR UNDERGROUND LOCATION  
2 WORKING DAYS BEFORE YOU DIG

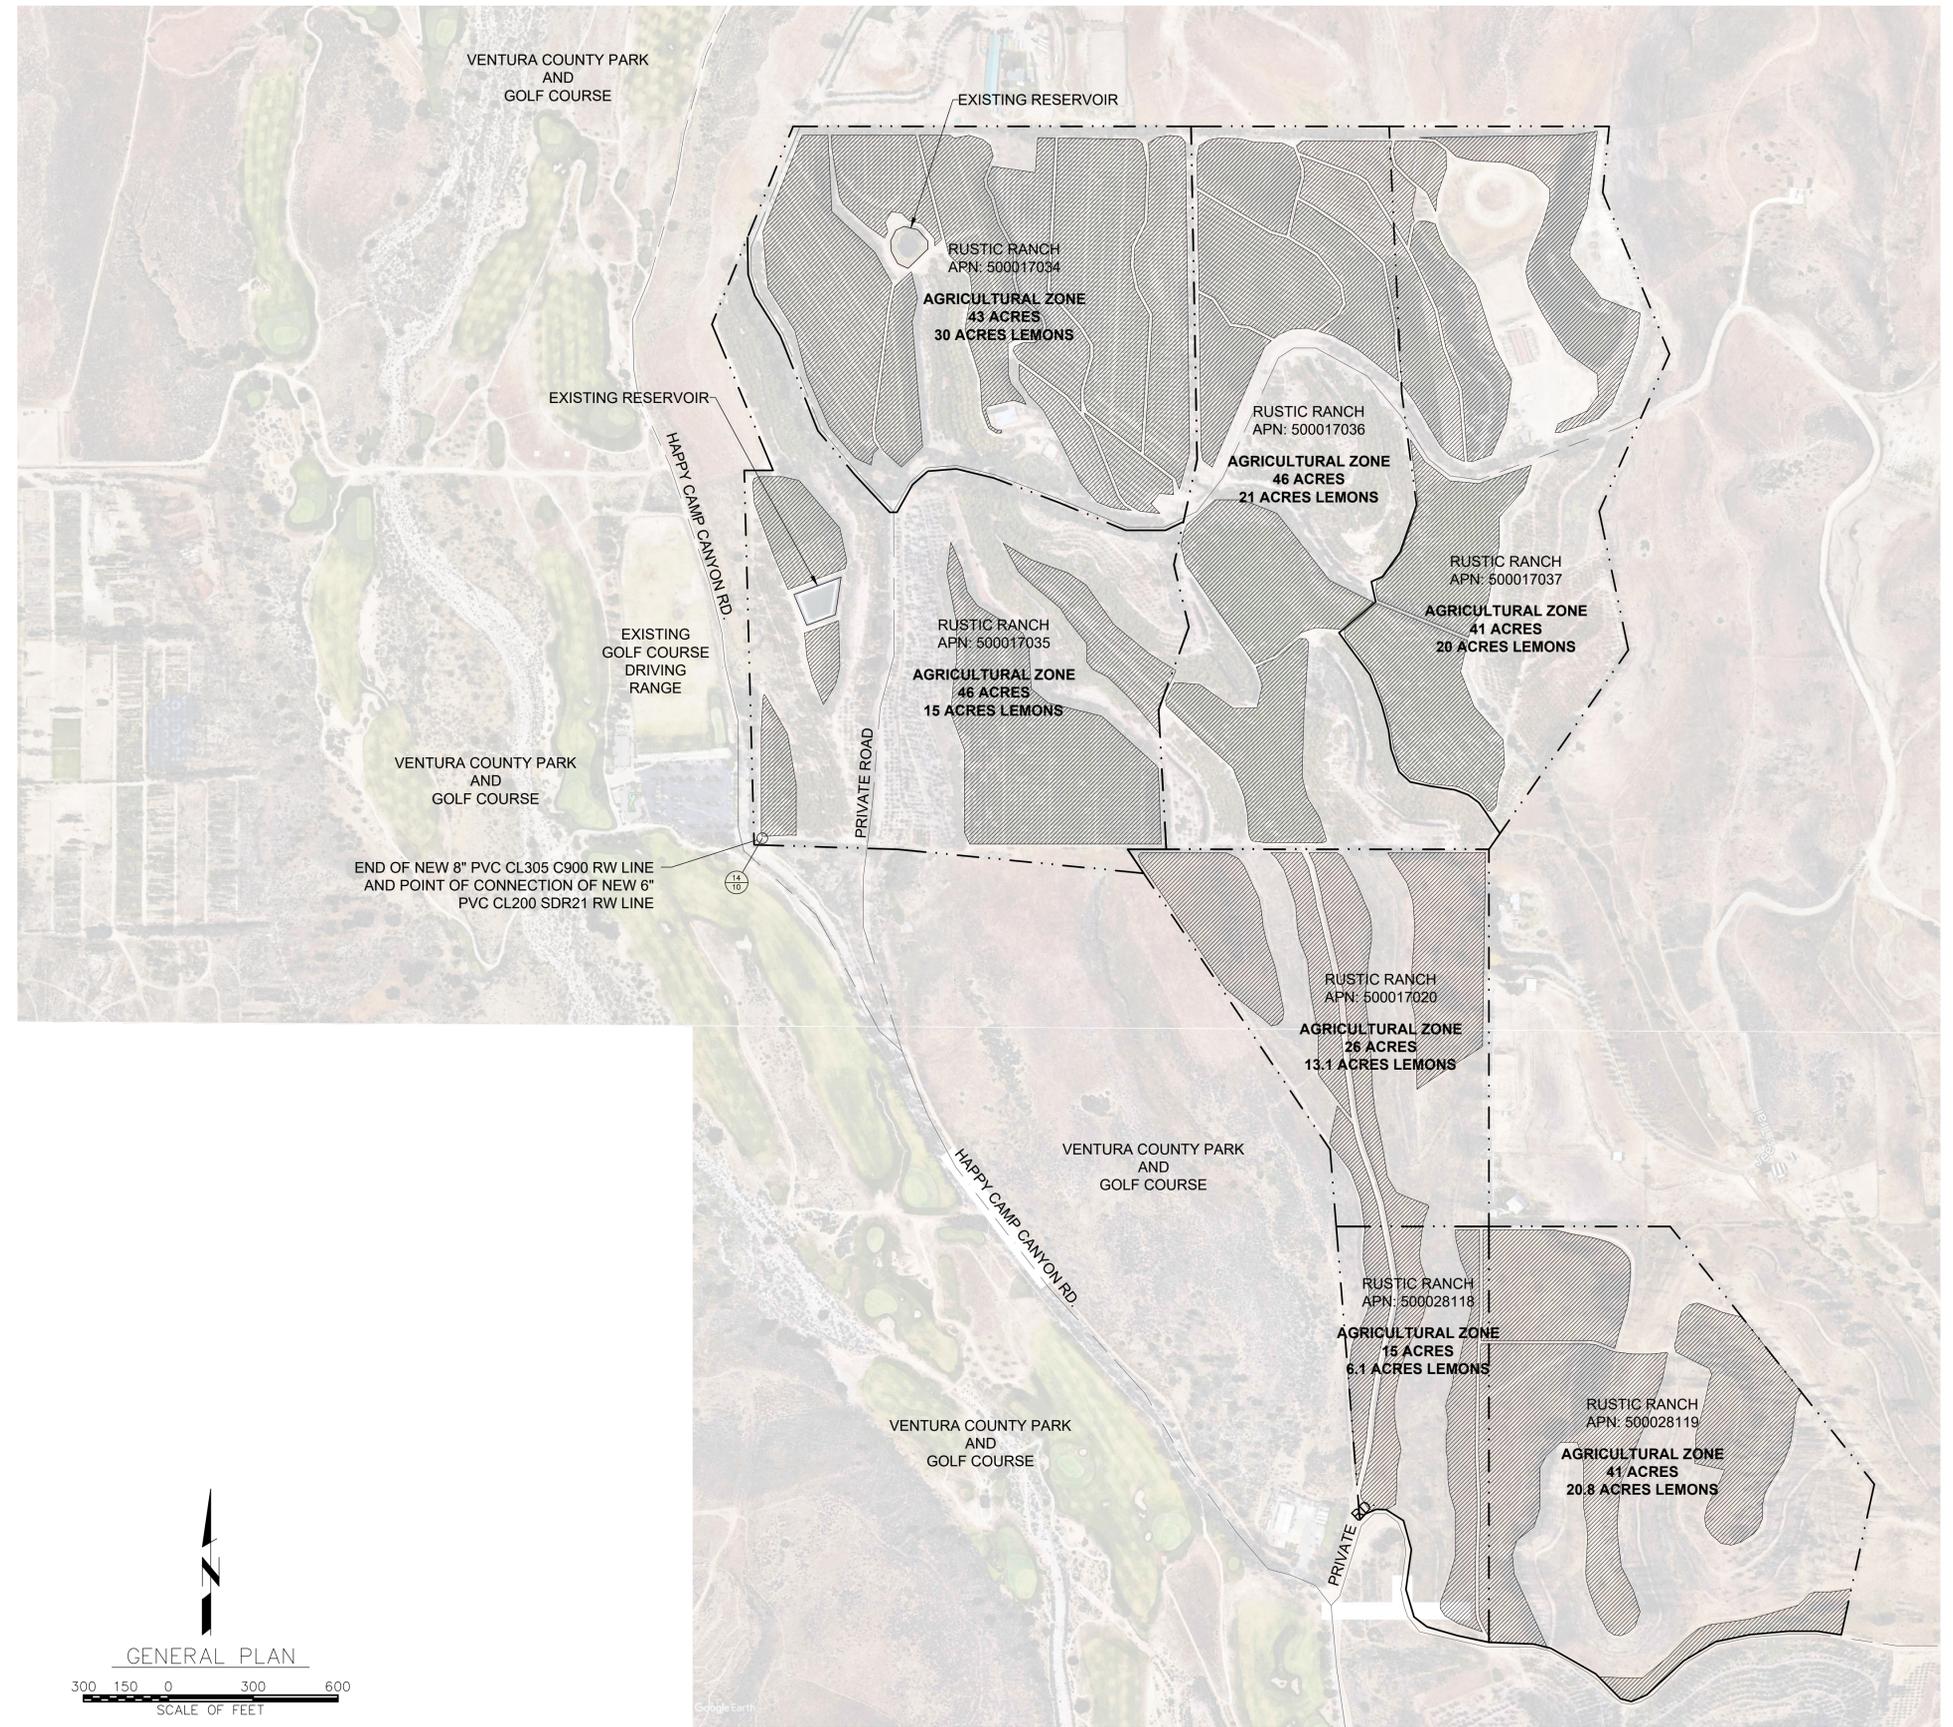

GENERAL PLAN



PLOT DATE: 5/2/20

SAVE DATE: 5/2/20 OWNER G:\USERS\OWNER\DESKTOP\19-087 RUSTIC VALLEY FARMS RW SYSTEM - EXPORT COPY-IRRIGATION-4-2-20\19-087 RUSTIC VALLEY FARMS RW SYSTEM.DWG

REVISION	DESCRIPTION	APP.	DATE
D			
C			
B			
A			



**IRRIGATION SERVICES**  
980 W. TELEGRAPH RD.  
SANTA PAULA, CA 93060  
OFFICE: (805) 933-2723  
FAX: (805) 933-2557  
KEVIN PROW: (805) 354-4143

KEVIN PROW SALES PERSON	10/4/2019 DATE
PAUL MCMURREY DESIGNER	10/4/2019 DATE
PAUL MCMURREY MATERIALS LIST	10/4/2019 DATE

OWNER:

KAM BABAOFF  
C/O LOUIS CICALES  
15101 MIDDLE RANCH RD.  
MOORPARK, CA 93021

SPEC. NO.	-
PROJ. NO.	-

RECYCLED WATER SYSTEM  
RUSTIC VALLEY FARMS  
GENERAL PLAN

SHEET	6
OF	11
DRAWING NO.	19-087